



### SHEET NOTES

- ① POWER CONNECTION TO DOOR HOLDER SOLENOID INSIDE THE DOOR TRACK ASSEMBLY BOX.
- ② DELETED
- ③ DELETED
- ④ PROVIDE 4" SQUARE BOX ABOVE CEILING AND CONDUIT/WIRING TO THE DOOR TRACK BUILT-IN SMOKE DETECTOR.
- ⑤ COORDINATE DOOR SWING WITH THE ARCHITECT

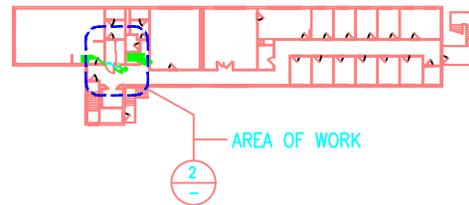

① **SECOND FLOOR KEY PLAN**   
 55-E2.2 SCALE: 1/32"=1'-0"

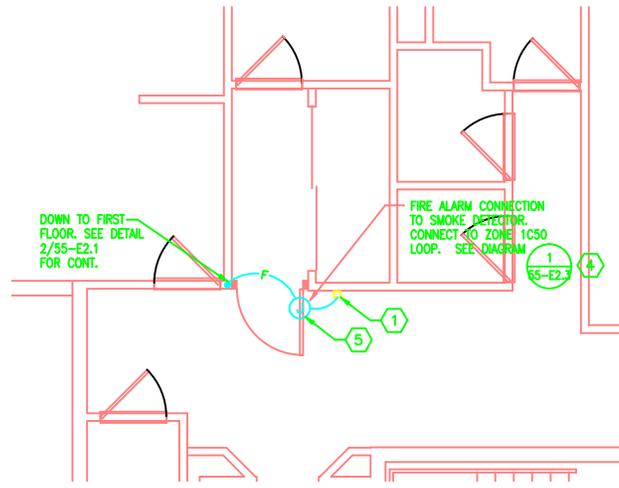


② **SECOND FLOOR PLAN - SIGNAL**   
 55-E2.2 SCALE: 1/4"=1'-0"

**ESS ARCHITECTS**  
 446 Eighth Street  
 San Francisco, CA 94103  
 415 392-0520  
 415 392-1045 Fax

**CONSULTANT**  
**MAZZETTI & ASSOCIATES, INC.**  
 Consulting Mechanical & Electrical Engineers  
 1000 DIVISadero STREET - SAN FRANCISCO, CA 94103-4871  
 TELEPHONE (415) 864-2800 FAX (415) 864-4303  
 / 41-285

REVISIONS	no.	date	description
AS BUILT	7/25/97		
100% TITLE II	11/7/94		
FINAL TITLE II	2/13/95		
REISSUE FINAL TITLE II	3/30/95		
FIRE ALARM SCHEMatics	REV. 1/15/95		
ISSUED FOR CONSTR.	9/19/95		
REVISED AS SHOWN BY	LEBL 10/2/95		

**JOB TITLE**  
**FIRE AND SAFETY SYSTEMS UPGRADE**  
**PHASE I**  
**LAWRENCE BERKELEY LABORATORY, UNIVERSITY OF CALIFORNIA**  
**BERKELEY, CALIFORNIA**

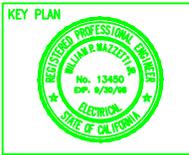

ESS ARCHITECTS JOB #: 9292  
 LBL SC#: 728  
 LBL FILE DRAWING:  
 ACAD FILE NAME:  
 LBNL DWG. **3N55E080J**  
 PROJ # 120257

**SHEET TITLE:**  
 BLDG. 55  
 SECOND FLOOR PLAN -  
 SIGNAL  
 SCALE: 1/8"=1'-0" | DATE: 7/15/95  
**SHEET:**  
**55-E2.2J**