



NOTES:
1. "NTD" TO GET 4-PR CABLE FROM THE ELECTRIC SHOP AND INSTALL IT FROM "FACP" TO TELCO CLOSET. LEAVE 15 FEET OF CABLE AT "FACP" END. CONNECT 1-PR ON OTHER END IN TELCO CLOSET TO BLDG 48. REFER TO WORK ORDER TO "TSC" FOR SUCH CONNECTIONS.

1 FLOOR PLAN-84-1
1/8" = 1'-0"

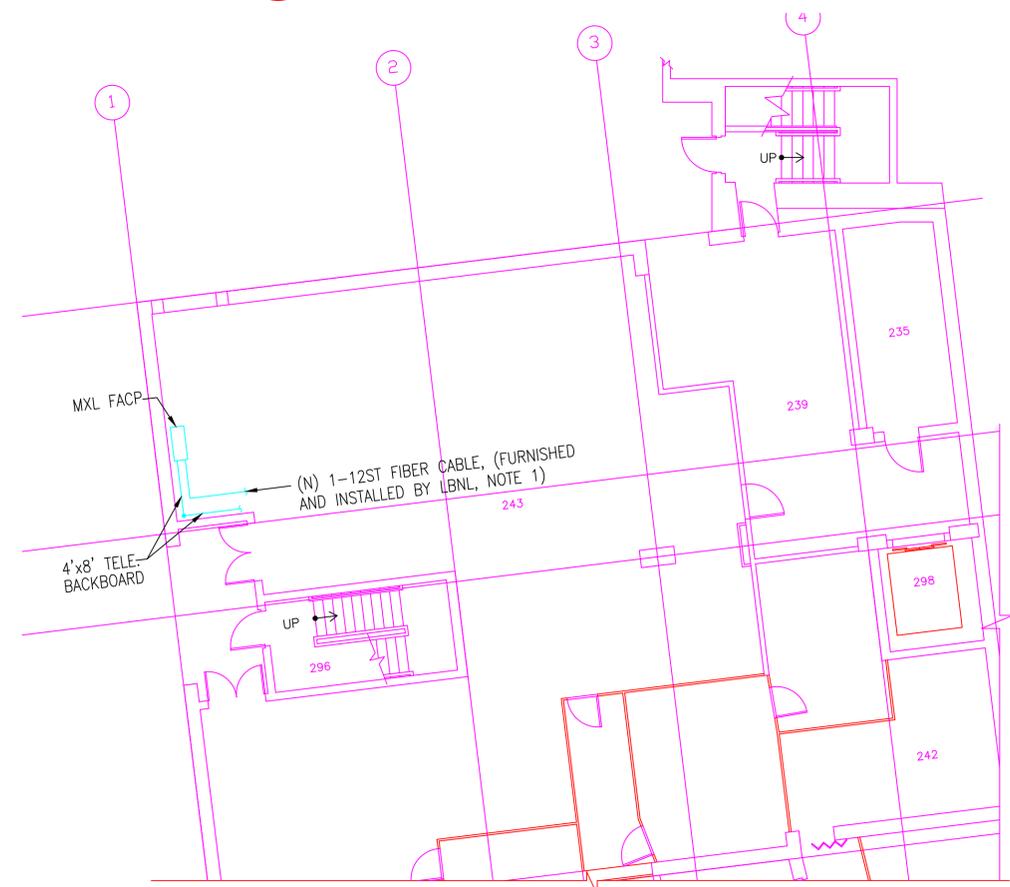

2 FLOOR PLAN-50B-B
1/8" = 1'-0"

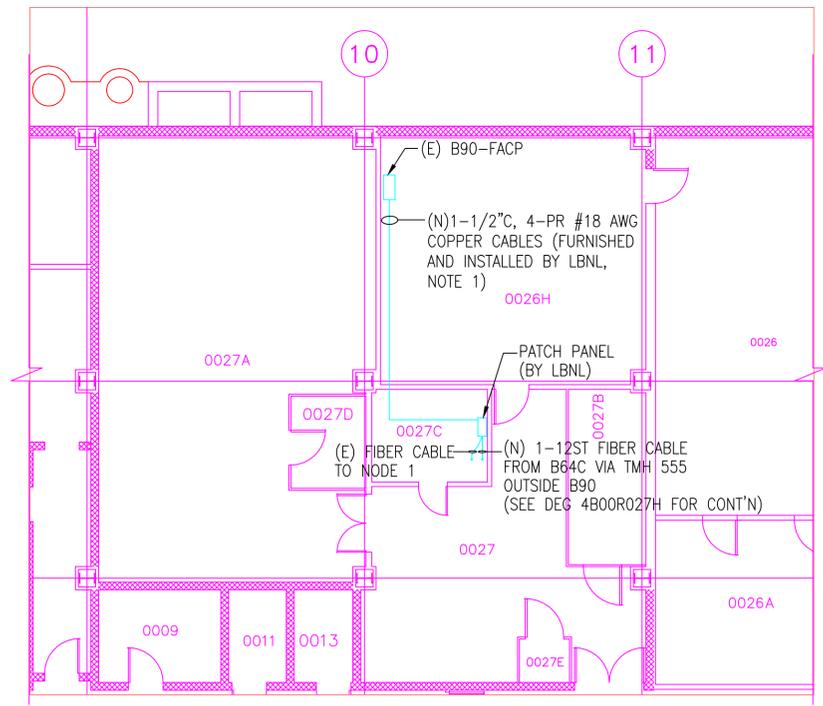

3 FLOOR PLAN-90-B
1/8" = 1'-0"

PROFESSIONAL SEAL (IF REVISION, APPLIES ONLY TO REVISED WORK)	TITLE 2 CONSTRUCTION						48 SCADA FIBER NETWORK PARTIAL FLOOR PLAN	DRAWN BY	IPM	DATE	2/15/2005
	2/15/2005							CHECKED BY		APPROVED BY	
ISSUE (PROGRESS, ESTIMATE, BID, CONSTRUCTION, CONFORMED, REVISION, RECORD)	REVISION NUMBER	DRAWN BY	CHECKED BY	APPR'D BY	DATE	REMARKS	CAD FILE PATH	00018981	SCALE	As Noted	
							DRAWING NO.	4B48E034_	SHEET	E-4	
							UNIVERSITY OF CALIFORNIA LAWRENCE BERKELEY NATIONAL LABORATORY FACILITIES DIVISION	PROJECT NO.	FE5012	4 OF 5	