


ALL DOOR HOLDERS AND CZM REMOTE ZONE MODULES SHALL BE POWERED BY 24VDC FROM MXL MMB-3 TB-5 LOCATED IN ELECTRICAL ROOM 118A.

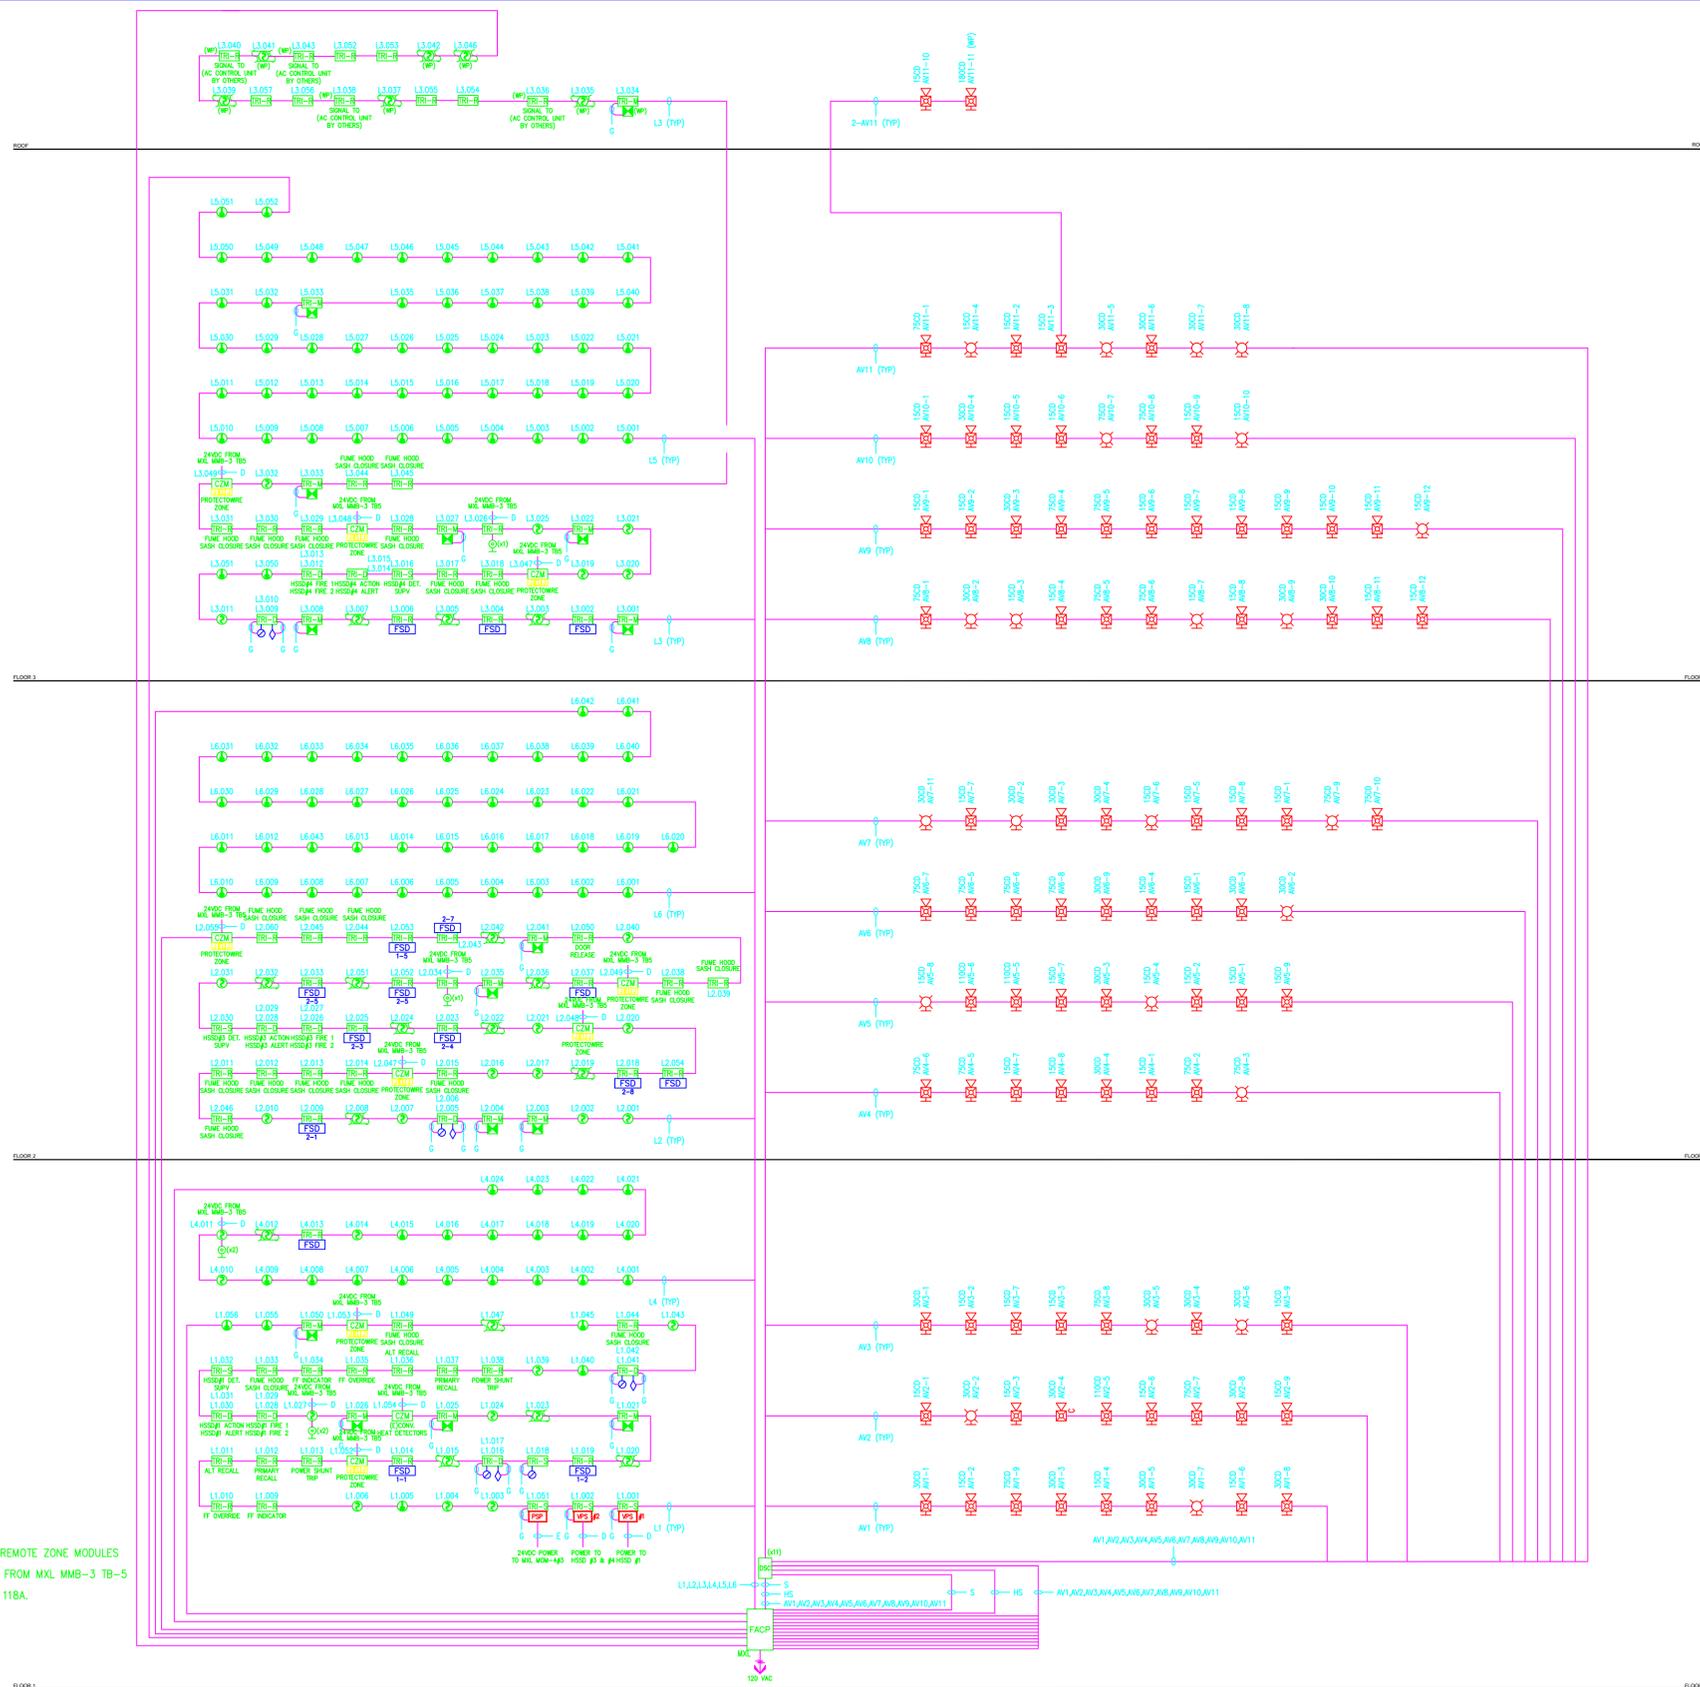

PROFESSIONAL SEAL  
(IF REVISION, APPLIES ONLY TO REVISED WORK)

AS BUILT	ISSUE	REVISION NUMBER	DRAWN BY	CHECKED BY	APPR'D BY	DATE	REMARKS
08/28/13	(PROGRESS, ESTIMATE, BID, CONSTRUCTION, CONFORMED, REVISION, RECORD)		DSV	LDD	MCD	08/28/13	AS BUILT FROM A/E RECORD DWGS

74 FIRE ALARM SYSTEM  
RISER DIAGRAM

UNIVERSITY OF CALIFORNIA  
LAWRENCE BERKELEY NATIONAL LABORATORY  
FACILITIES DIVISION

DRAWN BY	DATE
DSV	08/28/13
CHECKED BY	
LDD	09/03/2013
APPROVED BY	
MCD	09/03/2013
SCALE	AS NOTED
DRAWING NO.	SHEET
4B74E306	
PROJECT NO.	
FN9200	5 OF 20