


BT-34 BATTERY MODULE

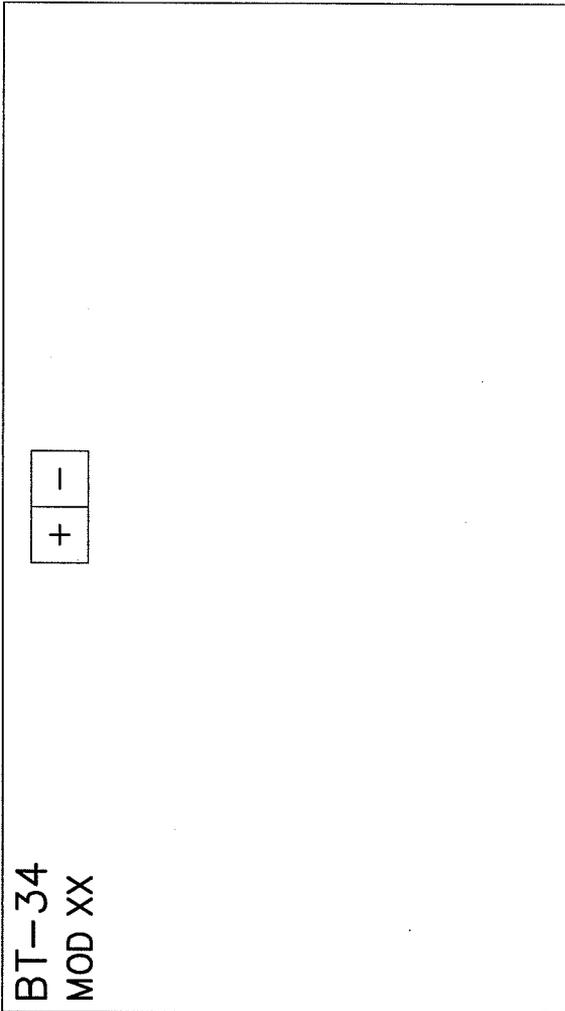

24VDC, 10.0 AH

(OCCUPIES 2 MODULE SPACES)

LBNL ELECTRICAL STANDARDS
FIRE ALARM SYSTEM
BT-34 BATTERY MODULE

| | |
|-----------------------------|-------|
| DRAWN BY | DATE |
| CHECKED BY | |
| APPROVED BY | |
| CAD FILE PATH | |
| SCALE NTS | |
| DRAWING NO. FA130 | SHEET |
| PROJECT NO. | |

UNIVERSITY OF CALIFORNIA LAWRENCE BERKELEY NATIONAL LABORATORY
FACILITIES DIVISION