


**PS-35 POWER SUPPLY**  
FOR USE WITH CP-35

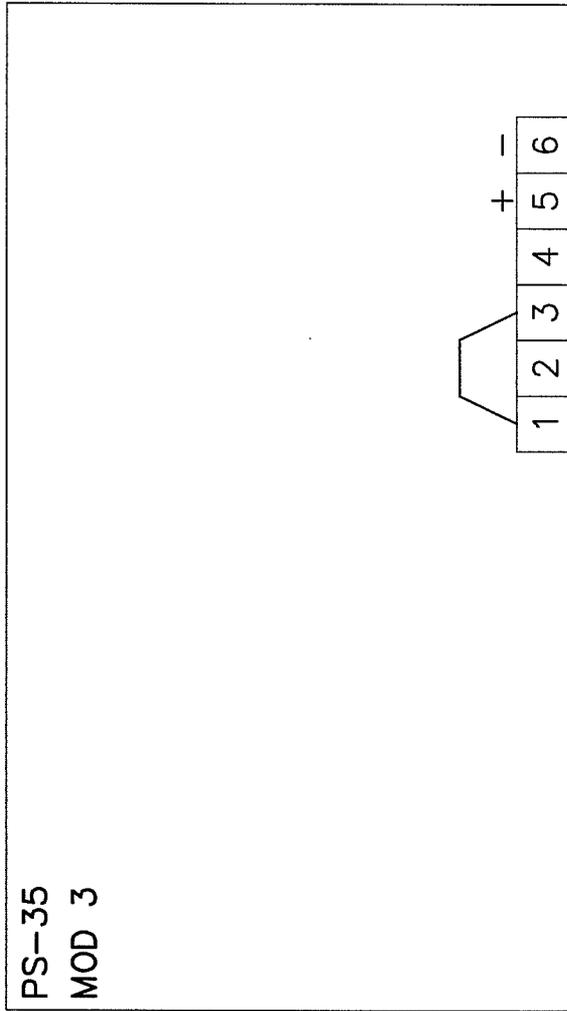

INPUT POWER { 3.5A MAX }  
120V, 50/60 HZ { 3/8A MAX }

24 VDC FULL WAVE  
10A MAX

GROUND WIRE CONNECTION

(OCCUPIES 3 MODULE SPACES AND SHOULD BE MOUNTED TO THE RIGHT OF THE CP-35)

LBNL ELECTRICAL STANDARDS  
FIRE ALARM SYSTEM  
PS-35 POWER SUPPLY

DRAWN BY	DATE
CHECKED BY	
APPROVED BY	
CAD FILE PATH	
SCALE NTS	
DRAWING NO. <b>FA132</b>	SHEET
PROJECT NO.	

UNIVERSITY OF CALIFORNIA LAWRENCE BERKELEY NATIONAL LABORATORY  
**FACILITIES DIVISION**