


BC-31 BATTERY CHARGER
 FOR USE WITH CP-31

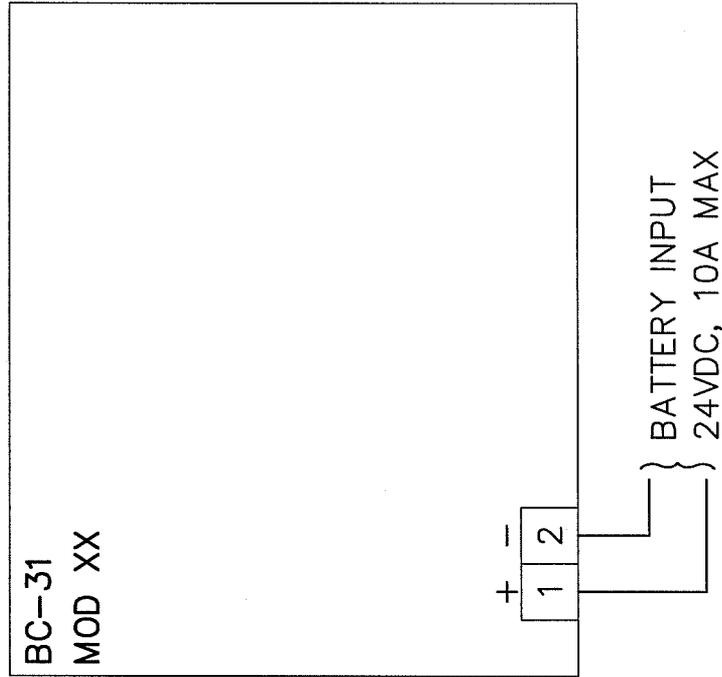

(OCCUPIES 2 MODULE SPACES)

LBNL ELECTRICAL STANDARDS
 FIRE ALARM SYSTEM
 BC-31 BATTERY CHARGER

DRAWN BY	DATE
CHECKED BY	
APPROVED BY	
CAD FILE PATH	
SCALE NTS	

UNIVERSITY OF CALIFORNIA LAWRENCE BERKELEY NATIONAL LABORATORY
FACILITIES DIVISION

DRAWING NO. FA134	SHEET
PROJECT NO.	